


VICINITY MAP

SCALE IN MILES
0 1 2 3 4 5 6

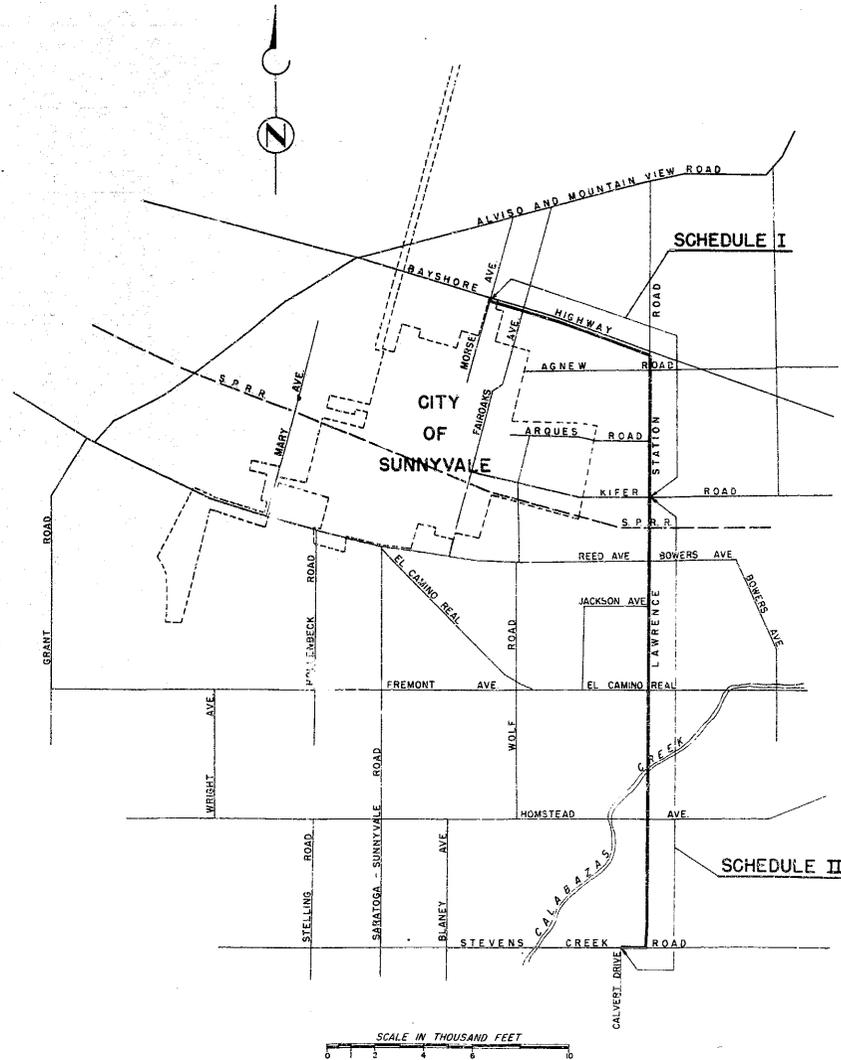


SCALE IN THOUSAND FEET
0 1 2 3 4 5 6 10

INDEX OF DRAWINGS	
1	LOCATION MAP AND INDEX OF DRAWINGS
PLAN AND PROFILE-TRUNK SEWER	
2	STATION 0 - STATION 57
3	STATION 57 - STATION 114
4	STATION 114 - STATION 171
5	STATION 171 - STATION 228
6	STATION 228 - STATION 257+51.62
PLAN AND PROFILE-PRESSURE SEWER	
7	STATION 0 - STATION 38
8	STATION 38 - STATION 67+02.51
9	MISCELLANEOUS DETAILS AND SOIL PROFILES




CITY OF SUNNYVALE	
LAWRENCE STATION ROAD TRUNK SEWER	
LOCATION MAP AND INDEX OF DRAWINGS	
BROWN AND CALDWELL, CIVIL AND CHEMICAL ENGINEERS SAN FRANCISCO, CALIFORNIA	
DRAWN 2/12	CHECKED 3/27
DATE 7-15-52	DWG. NO. 1


SS-1081

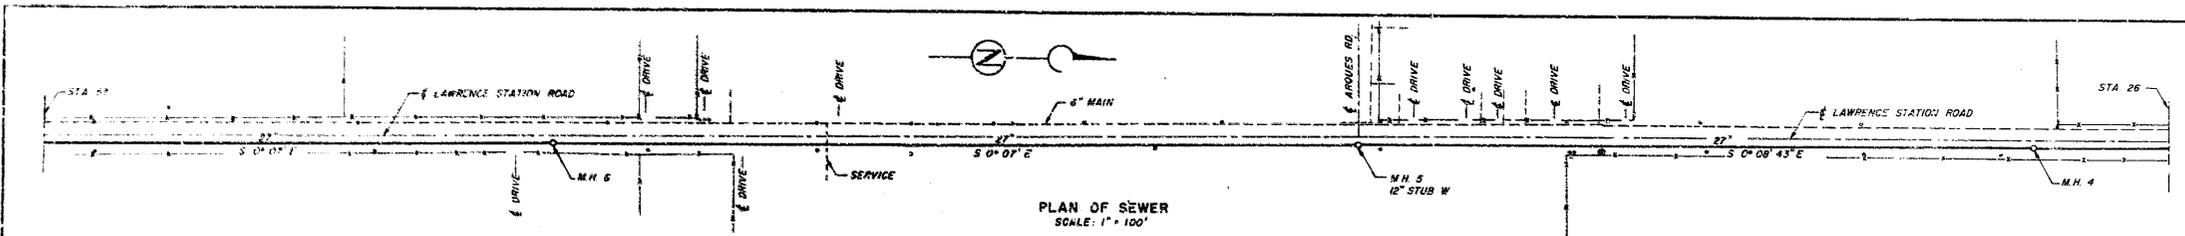


PLAN OF SEWER
SCALE: 1" = 100'

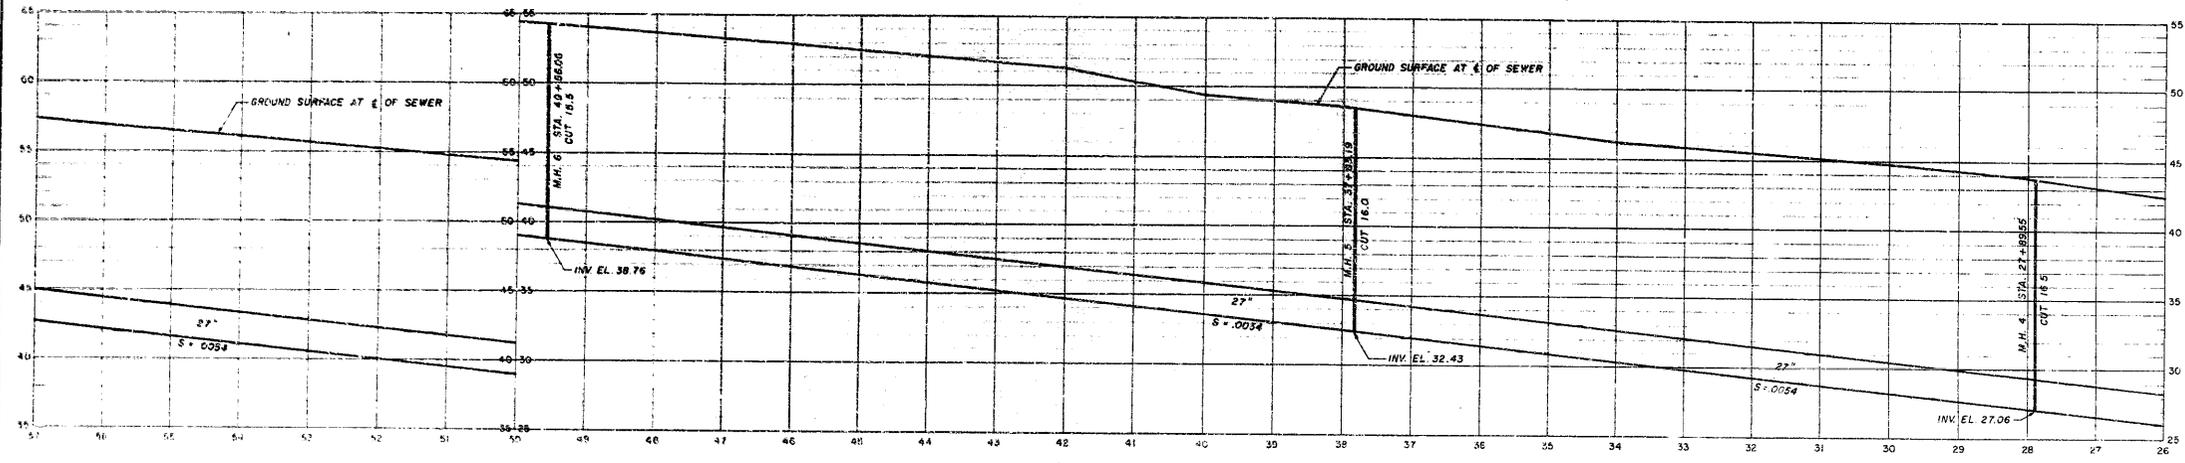

PROFILE AT C. OF SEWER
SCALE: HORIZ. 1" = 100', VERT. 1" = 5'

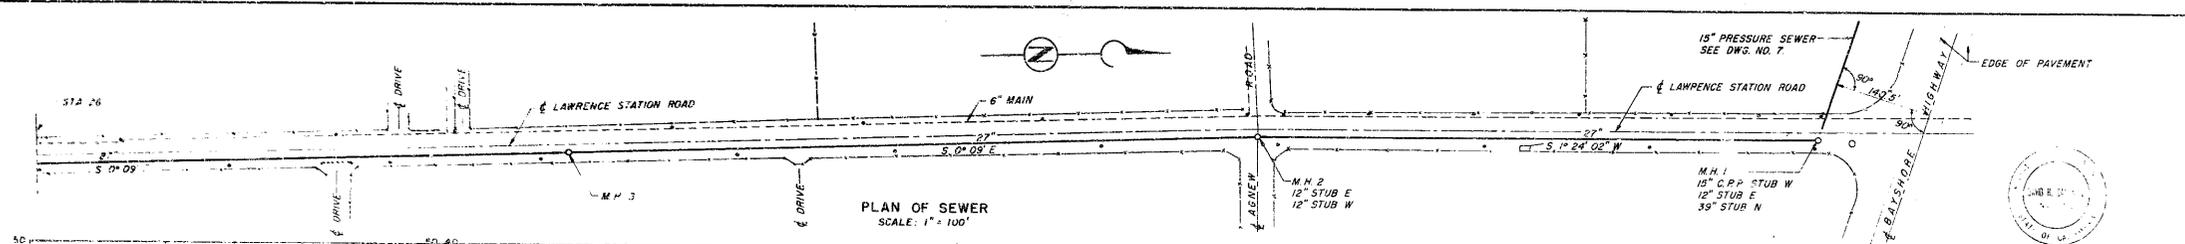

PLAN OF SEWER
SCALE: 1" = 100'

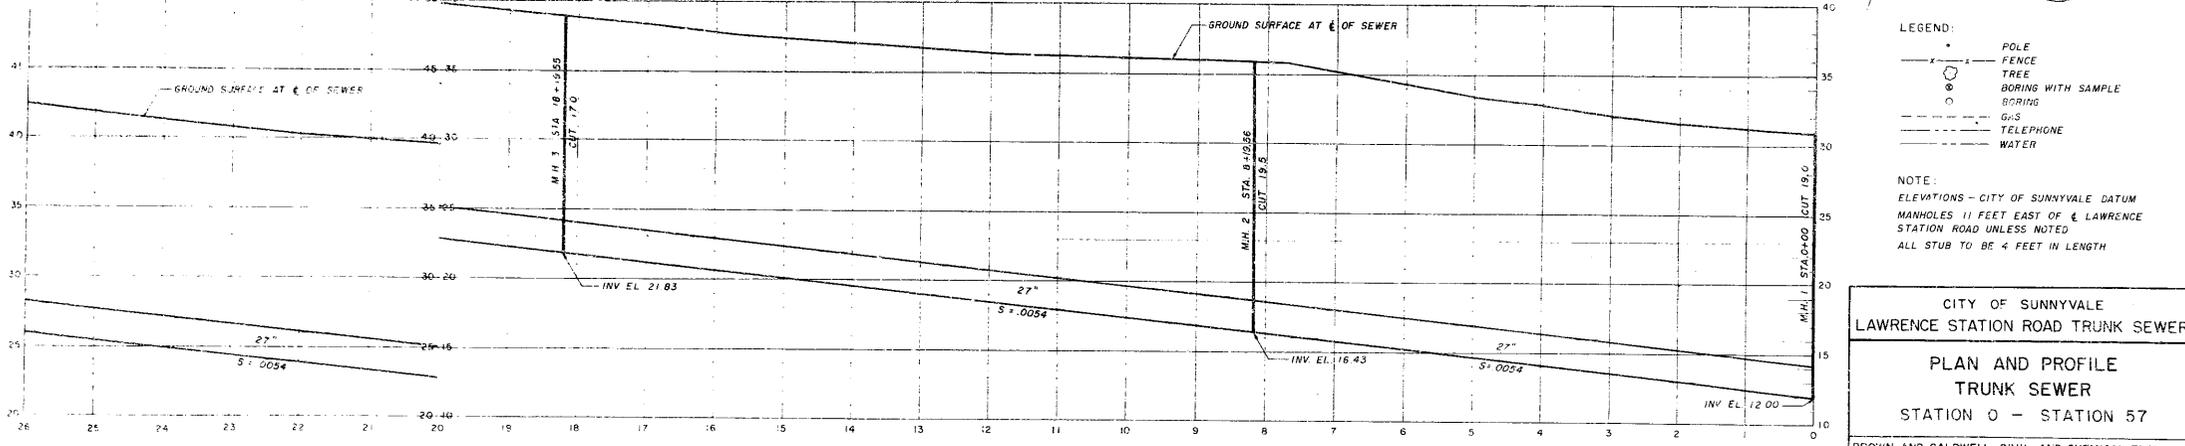

PROFILE AT C. OF SEWER
SCALE: HORIZ. 1" = 100', VERT. 1" = 5'

NOTE: 27" STANDARD STRENGTH 1,500 D. REINFORCED CONCRETE PIPE WITH COLLARS OR 27" EXTRA STRENGTH V. TRIPLED CLAY PIPE.


- LEGEND:
- POLE
 - FENCE
 - TREE
 - BORING WITH SAMPLE
 - BORING
 - - - G.S.
 - - - TELEPHONE
 - - - WATER

NOTE:
ELEVATIONS - CITY OF SUNNYVALE DATUM
MANHOLES 11 FEET EAST OF C. OF LAWRENCE STATION ROAD UNLESS NOTED
ALL STUB TO BE 4 FEET IN LENGTH


CITY OF SUNNYVALE LAWRENCE STATION ROAD TRUNK SEWER	
PLAN AND PROFILE TRUNK SEWER STATION 0 - STATION 57	
BROWN AND CALDWELL, CIVIL AND CHEMICAL ENGINEERS SAN FRANCISCO, CALIFORNIA	
DRAWN: _____	CHECKED: _____
DATE: 7-15-52	DWG. NO. 2

55-1082



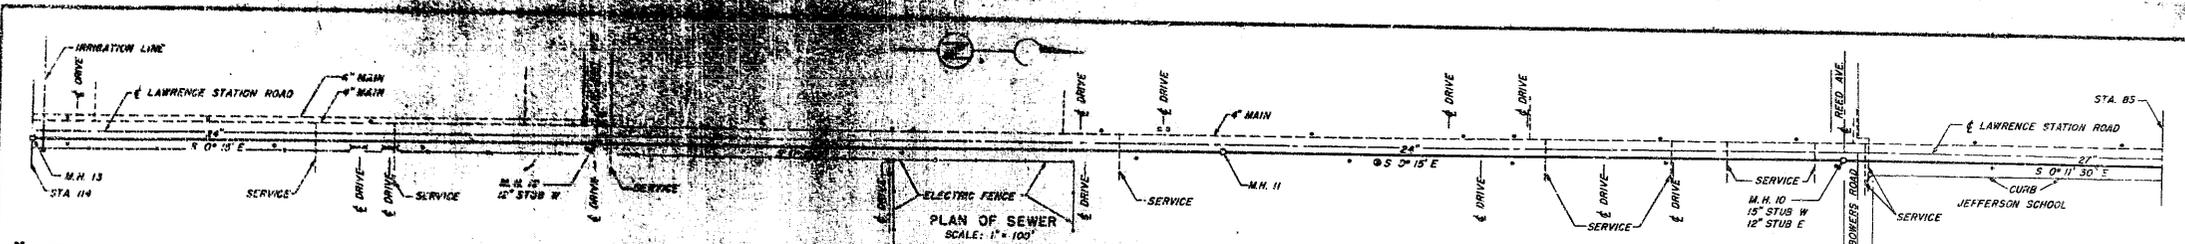


PLAN OF SEWER
SCALE: 1" = 100'

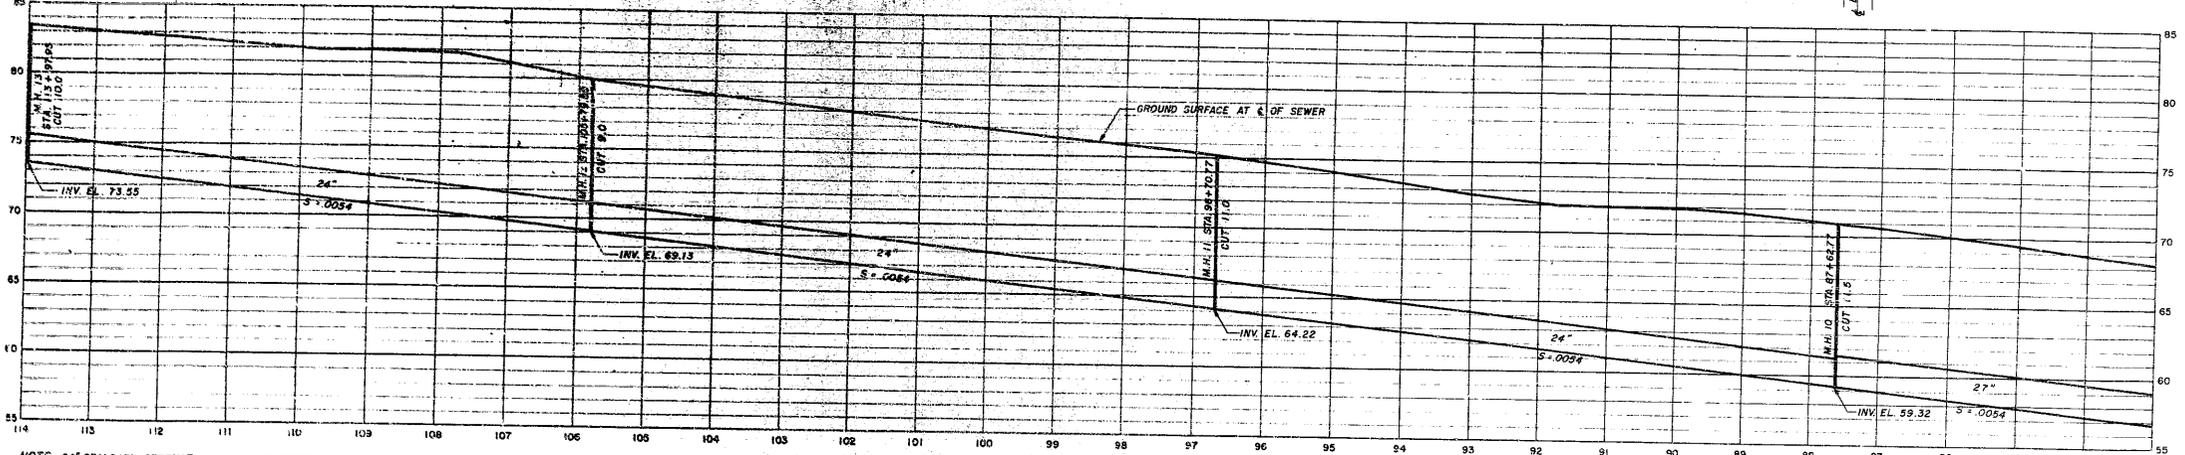


PROFILE AT & OF SEWER
SCALE: HORIZ. 1" = 100', VERT. 1" = 5'

NOTE 24" STANDARD STRENGTH (1500 D) REINFORCED CONCRETE WITH COLLARS OR
24" EXTRA STRENGTH VITRIFIED CLAY PIPE

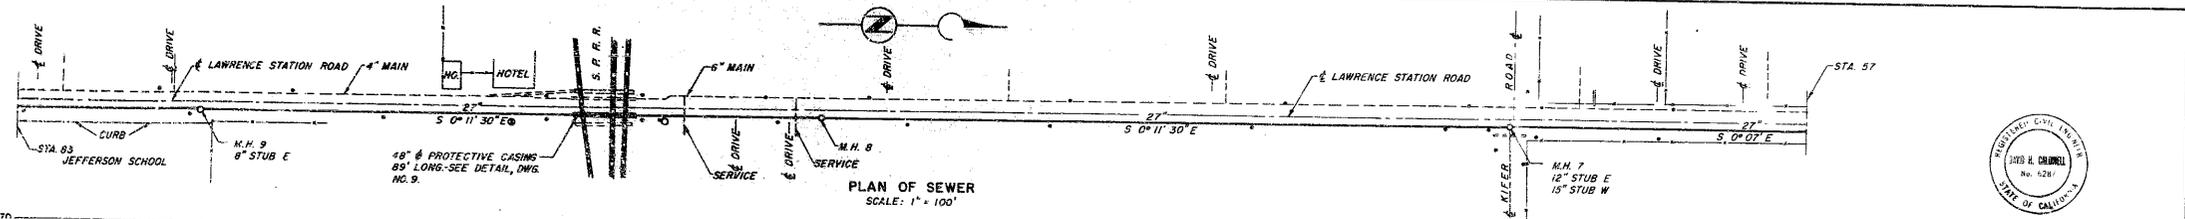

PLAN OF SEWER
SCALE: 1" = 100'

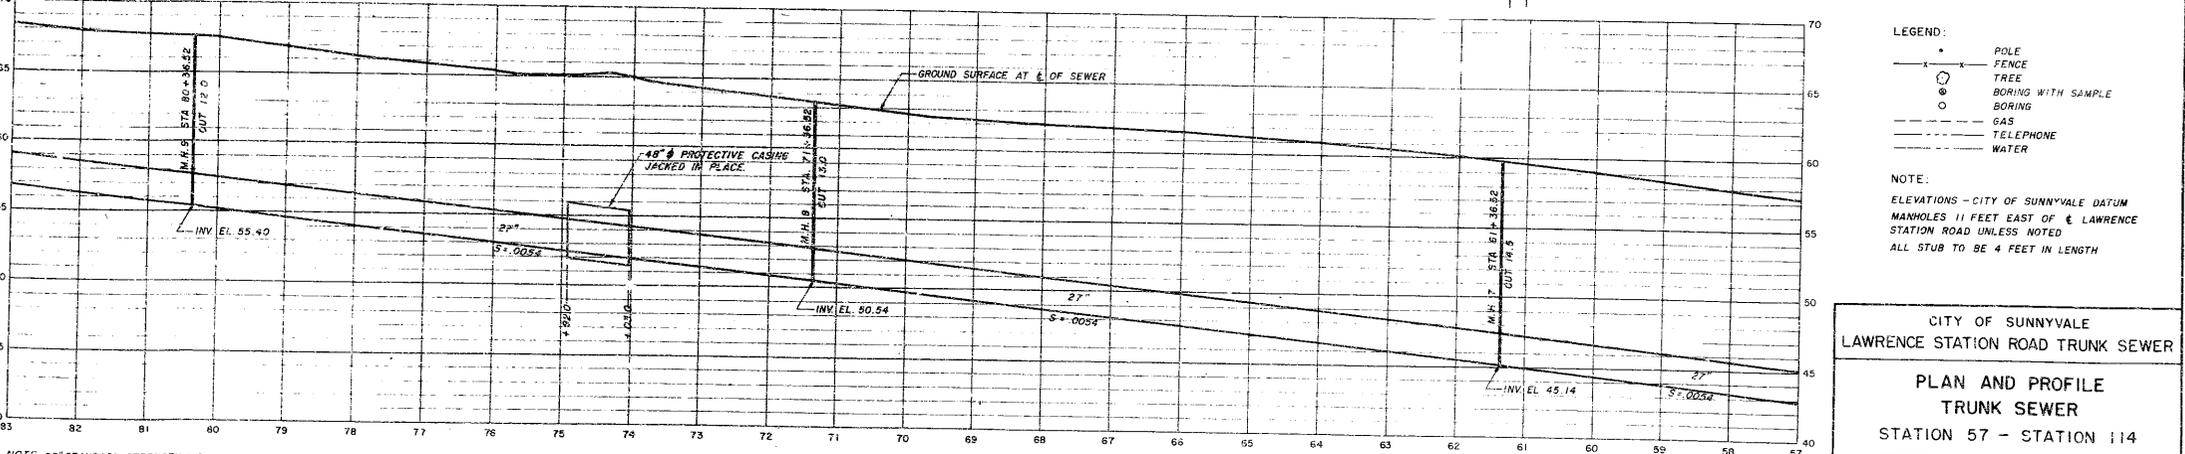

PROFILE AT & OF SEWER
SCALE: HORIZ. 1" = 100', VERT. 1" = 5'

NOTE 27" STANDARD STRENGTH (1500 D) REINFORCED CONCRETE PIPE WITH COLLARS OR
27" EXTRA STRENGTH VITRIFIED CLAY PIPE



- LEGEND:
- POLE
 - FENCE
 - TREE
 - BORING WITH SAMPLE
 - BORING
 - GAS
 - TELEPHONE
 - WATER



NOTE:
ELEVATIONS - CITY OF SUNNYVALE DATUM
MANHOLES 11 FEET EAST OF & LAWRENCE
STATION ROAD UNLESS NOTED
ALL STUB TO BE 4 FEET IN LENGTH

CITY OF SUNNYVALE
LAWRENCE STATION ROAD TRUNK SEWER

PLAN AND PROFILE
TRUNK SEWER
STATION 57 - STATION 114



BROWN AND CALDWELL, CIVIL AND CHEMICAL ENGINEERS
SAN FRANCISCO, CALIFORNIA
DRAWN BY: [initials] CHECKED BY: [initials] DATE: 7-15-52 DWG. NO. 3

55108.2

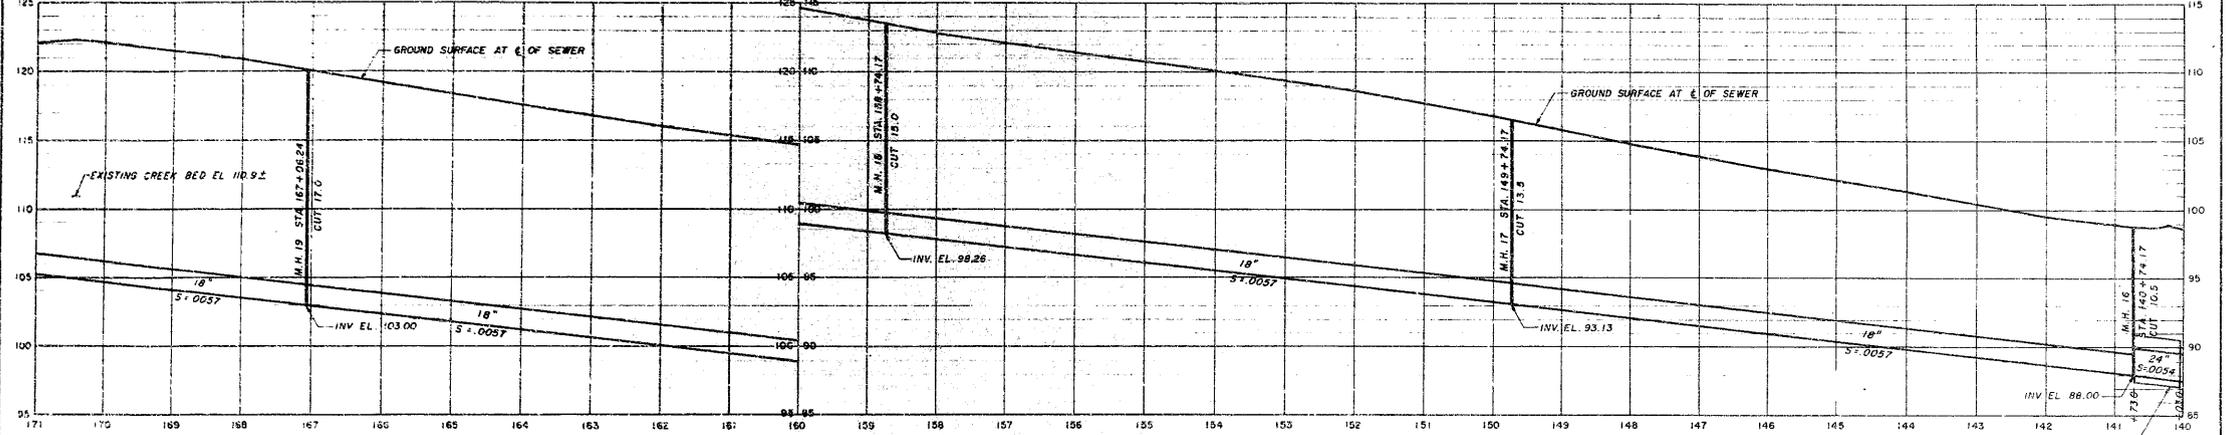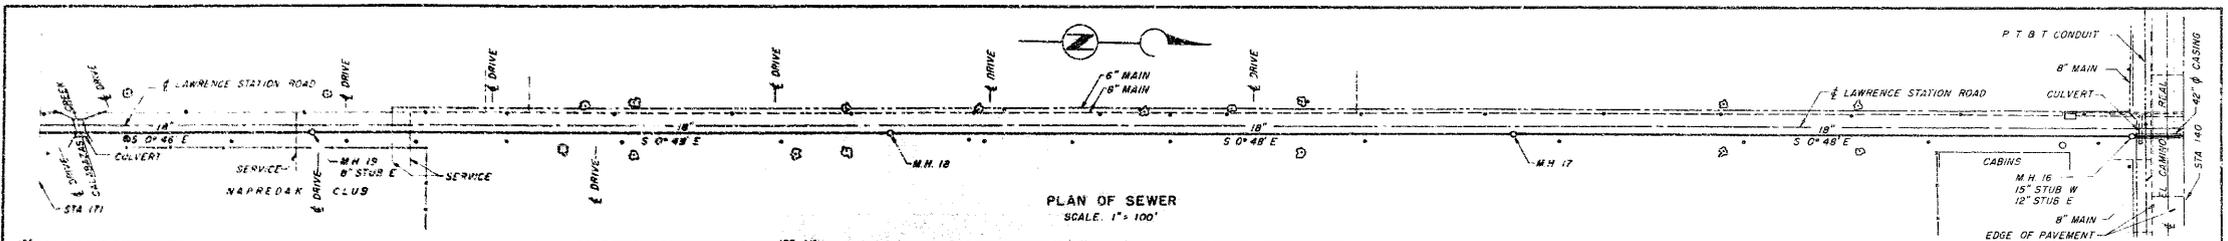

NOTE: 18" STANDARD STRENGTH (1500 D) REINFORCED CONCRETE PIPE OR
18" STANDARD STRENGTH VITRIFIED CLAY PIPE.

NOTE: 42" Ø PROTECTIVE CASING
JACKED IN PLACE, 20' LONG
SEE DETAIL DWG. NO. 9

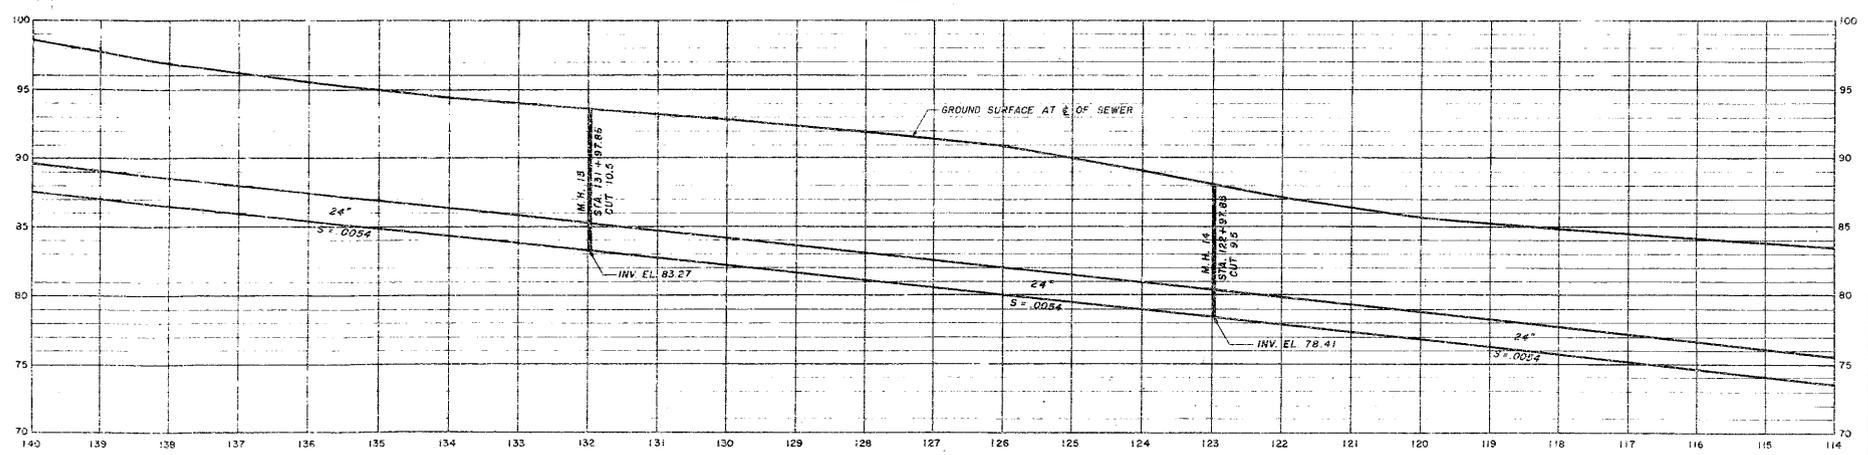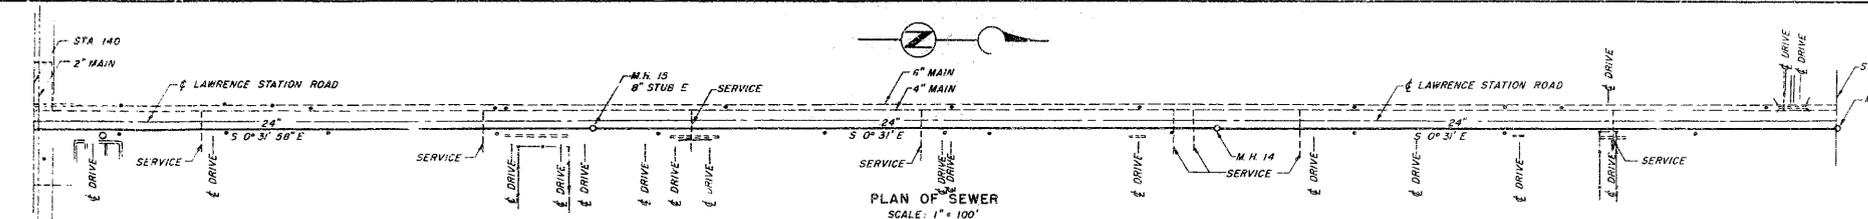

NOTE: 24" STANDARD STRENGTH (1500 D) REINFORCED CONCRETE PIPE WITH COLLARS OR
24" EXTRA STRENGTH VITRIFIED CLAY PIPE

NOTE: 42" Ø PROTECTIVE CASING
JACKED IN PLACE, 20' LONG
SEE DETAIL DWG. NO. 9

- LEGEND:**
- POLE
 - ⊗ FENCE
 - ⊙ BORING WITH SAMPLE
 - BORING
 - GAS
 - TELEPHONE
 - WATER



NOTE:
ELEVATIONS - CITY OF SUNNYVALE DATUM
MANHOLES 11 FEET EAST OF & LAWRENCE
STATION ROAD UNLESS NOTED
ALL STUB TO BE 4 FEET IN LENGTH

CITY OF SUNNYVALE
LAWRENCE STATION ROAD TRUNK SEWER
PLAN AND PROFILE
TRUNK SEWER
STATION 114 - STATION 171



BROWN AND CALDWELL, CIVIL AND CHEMICAL ENGINEERS
SAN FRANCISCO, CALIFORNIA

DRAWN BY J.J. CHECKED BY J.J. DATE 7-15-92 DWG NO. 4


55-108.4

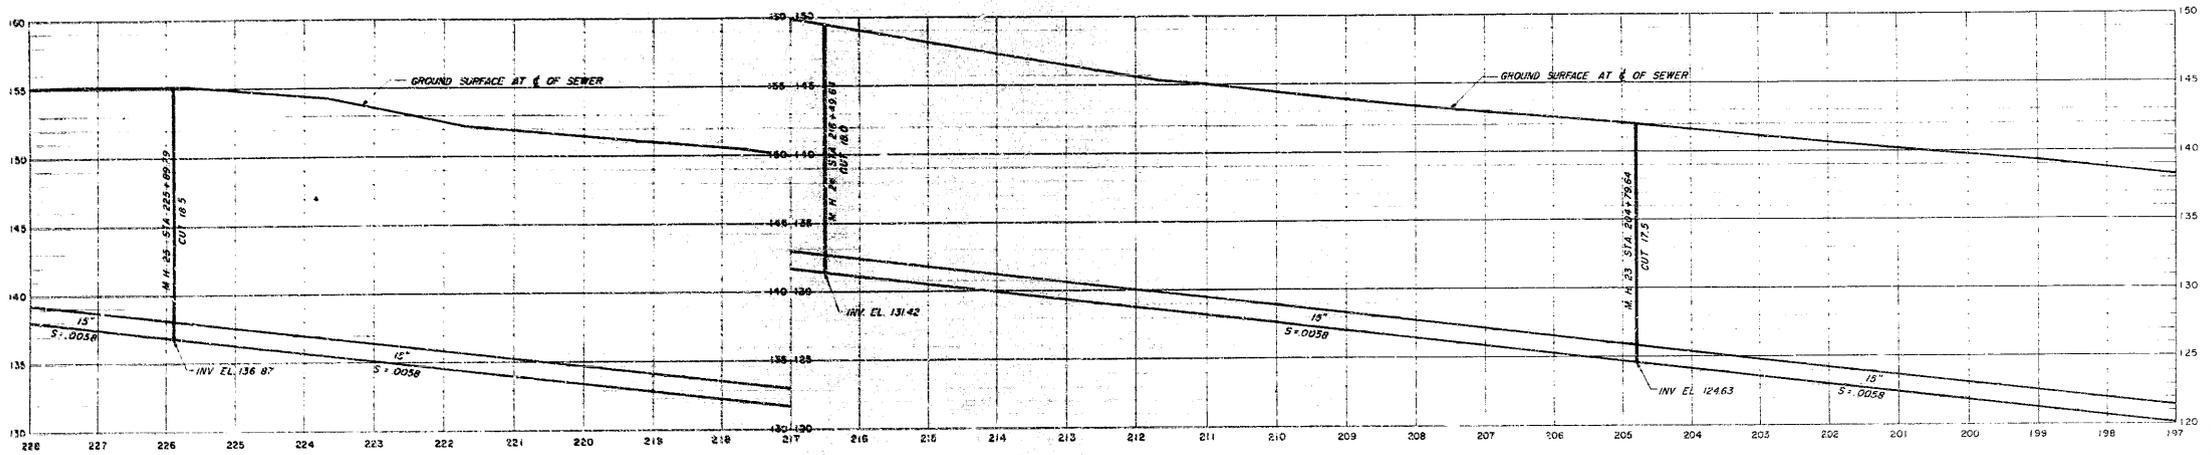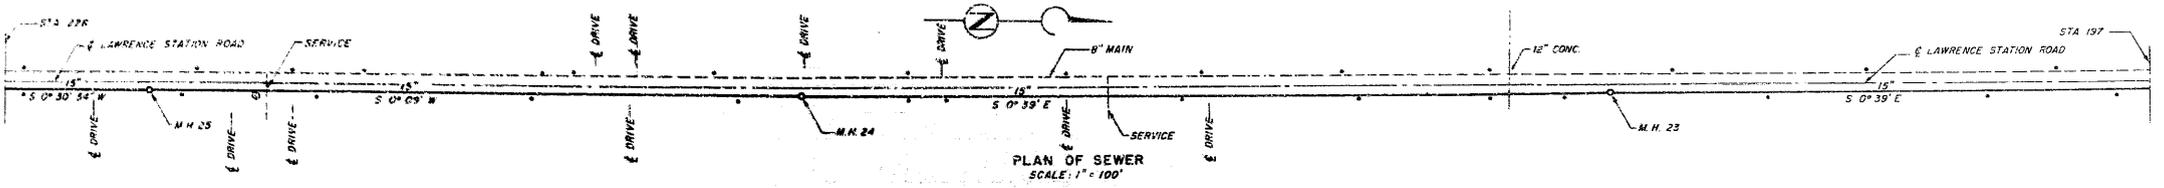

NOTE: 15" STANDARD STRENGTH (1500 D) REINFORCED CONCRETE PIPE OR 15" STANDARD STRENGTH VITRIFIED CLAY PIPE

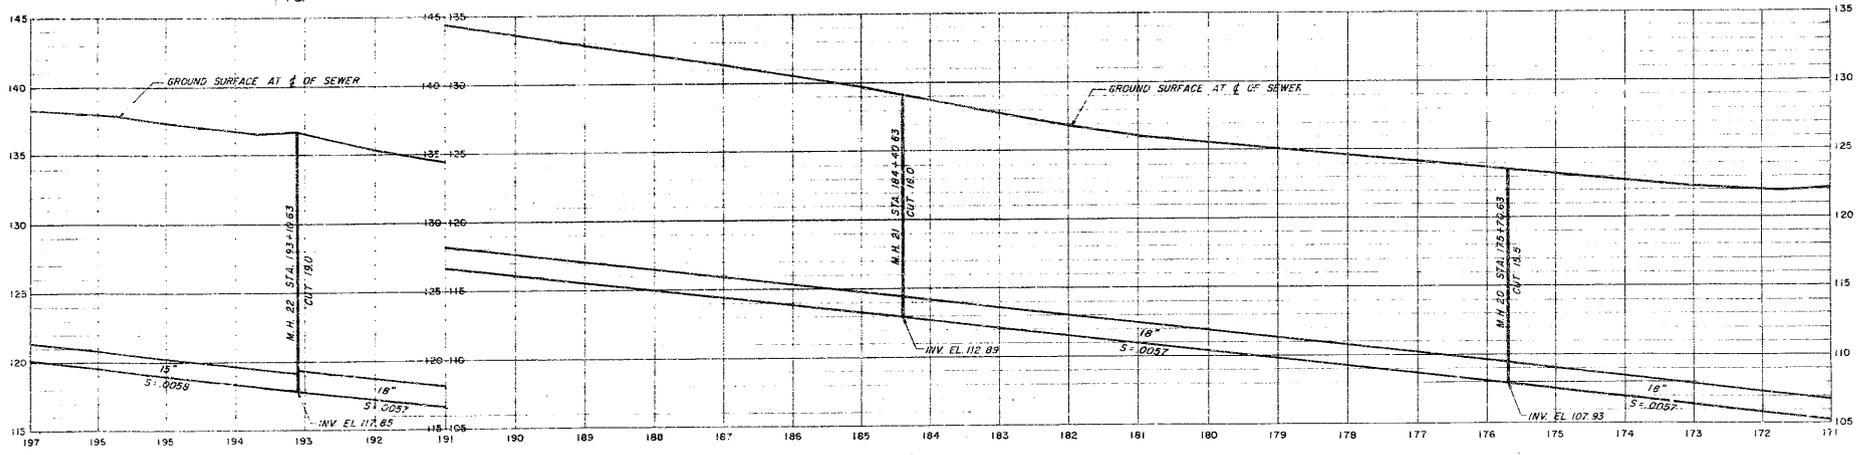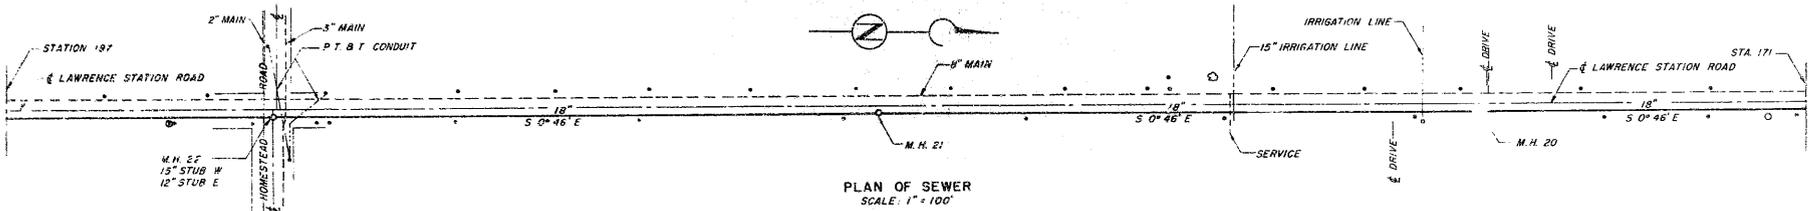

 NOTE: 18" STANDARD STRENGTH (1500 D) REINFORCED CONCRETE PIPE OR 18" STANDARD STRENGTH VITRIFIED CLAY PIPE



- LEGEND:
- POLE
 - FENCE
 - TREE
 - ⊙ BORING WITH SAMPLE
 - BORING
 - - - GAS
 - - - TELEPHONE
 - - - WATER

NOTE:
ELEVATIONS - CITY OF SUNNYVALE DATUM
MANHOLES 11 FEET EAST OF $\frac{1}{2}$ OF LAWRENCE STATION ROAD UNLESS NOTED
ALL STUB TO BE 4 FEET IN LENGTH

CITY OF SUNNYVALE
LAWRENCE STATION ROAD TRUNK SEWER



PLAN AND PROFILE
TRUNK SEWER
STATION 171 - STATION 228

BROWN AND CALDWELL, CIVIL AND CHEMICAL ENGINEERS
SAN FRANCISCO, CALIFORNIA

DRAWN: J.L. CHECKED: J.L. DATE: 7-15-52 DWG. NO.: 5



55-108.5



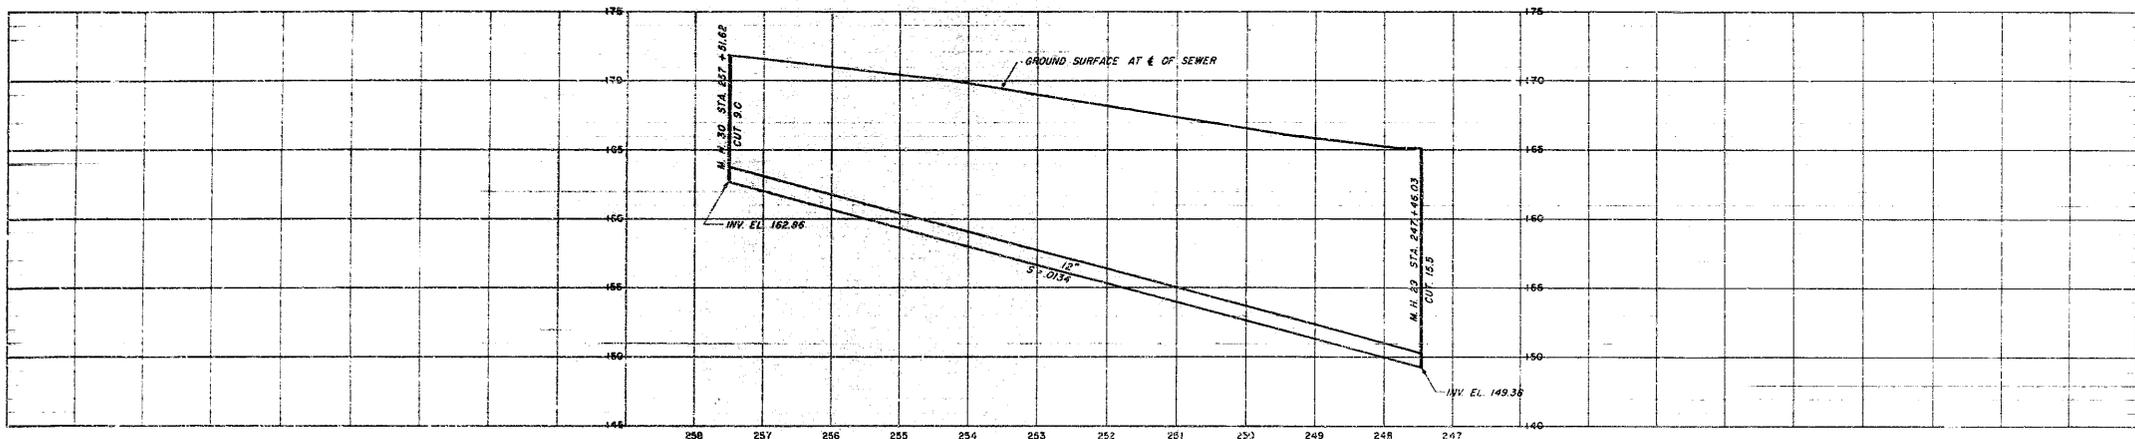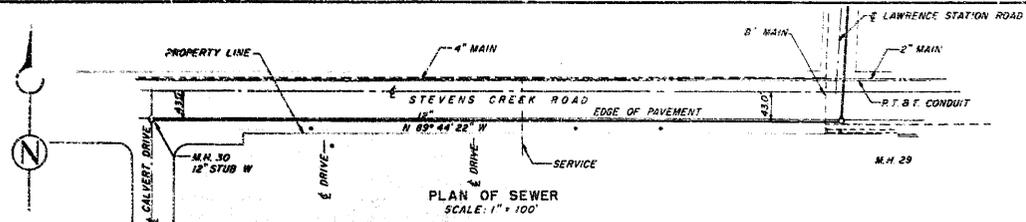

NOTE 15" STANDARD STRENGTH (1500 D) REINFORCED CONCRETE PIPE OR 15" STANDARD STRENGTH VITRIFIED CLAY PIPE.

PROFILE AT & OF SEWER
SCALE: HORIZ. 1" = 100', VERT. 1" = 5'

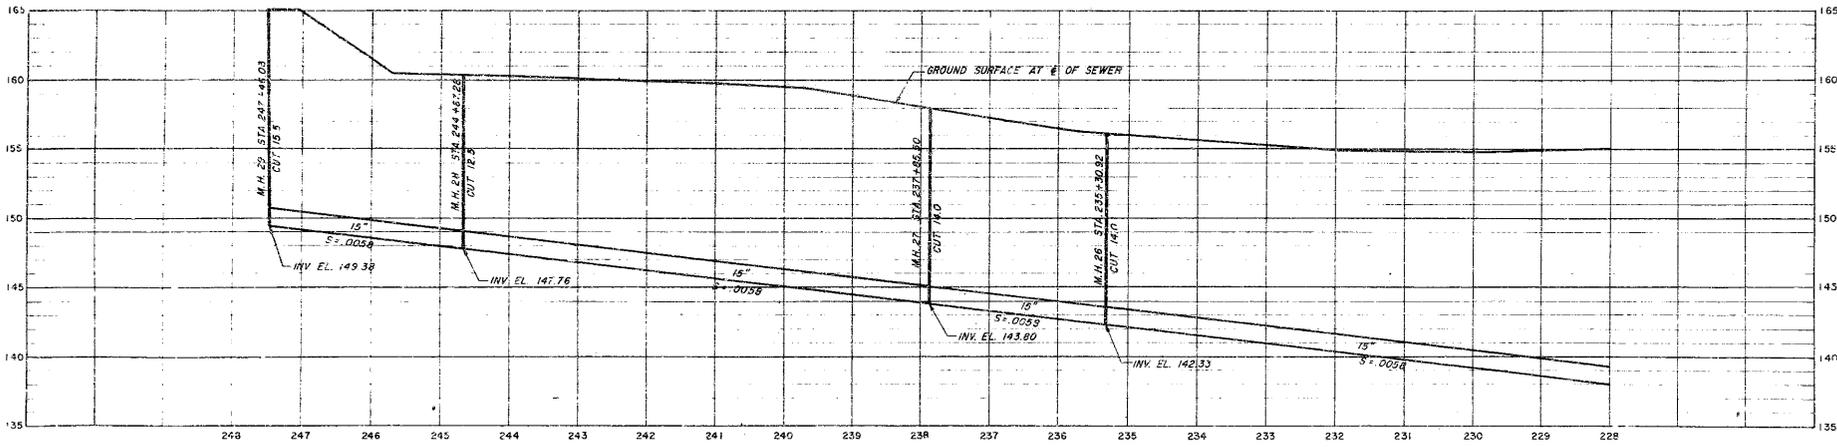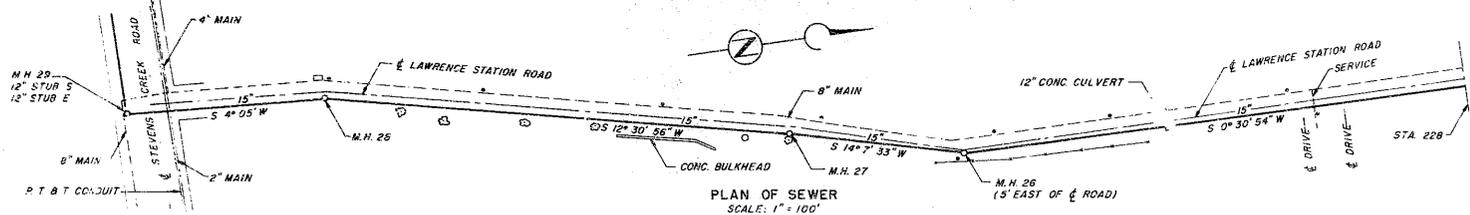

NOTE 15" STANDARD STRENGTH (1500 D) REINFORCED CONCRETE PIPE OR 15" STANDARD STRENGTH VITRIFIED CLAY PIPE.

PROFILE AT & OF SEWER
SCALE: HORIZ. 1" = 100', VERT. 1" = 5'

- LEGEND:
- POLE
 - FENCE
 - ⊗ BORING WITH SAMPLE
 - BORING
 - - - GAS
 - - - TELEPHONE
 - - - WATER

NOTE:
ELEVATIONS - CITY OF SUNNYVALE DATUM
MANHOLES 11 FEET EAST OF & OF LAWRENCE STATION ROAD UNLESS NOTED
ALL STUB TO BE 4 FEET IN LENGTH


CITY OF SUNNYVALE
LAWRENCE STATION ROAD TRUNK SEWER

PLAN AND PROFILE
TRUNK SEWER
STATION 228 - STATION 257 + 51.62


BROWN AND CALDWELL, CIVIL AND CHEMICAL ENGINEERS
SAN FRANCISCO, CALIFORNIA

DRAWN: [Signature] CHECKED: [Signature] DATE: 7-15-52 DWG. NO. 6


SS-108.6

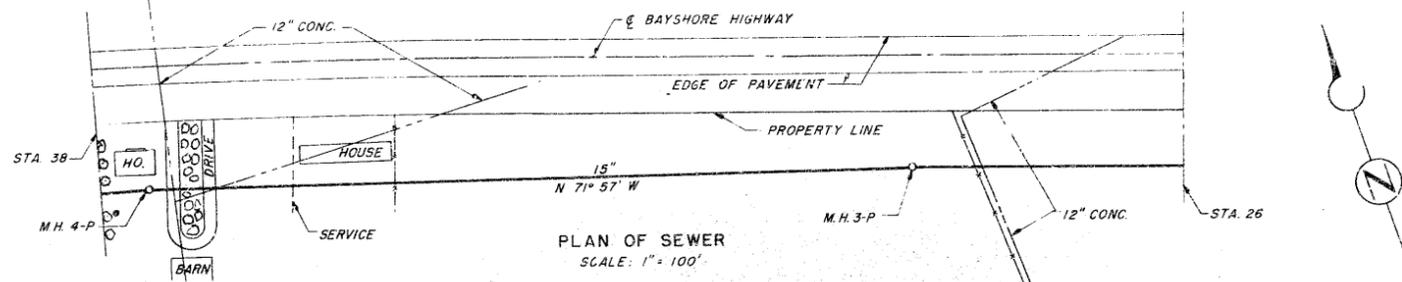


PLAN OF SEWER
SCALE: 1" = 100'

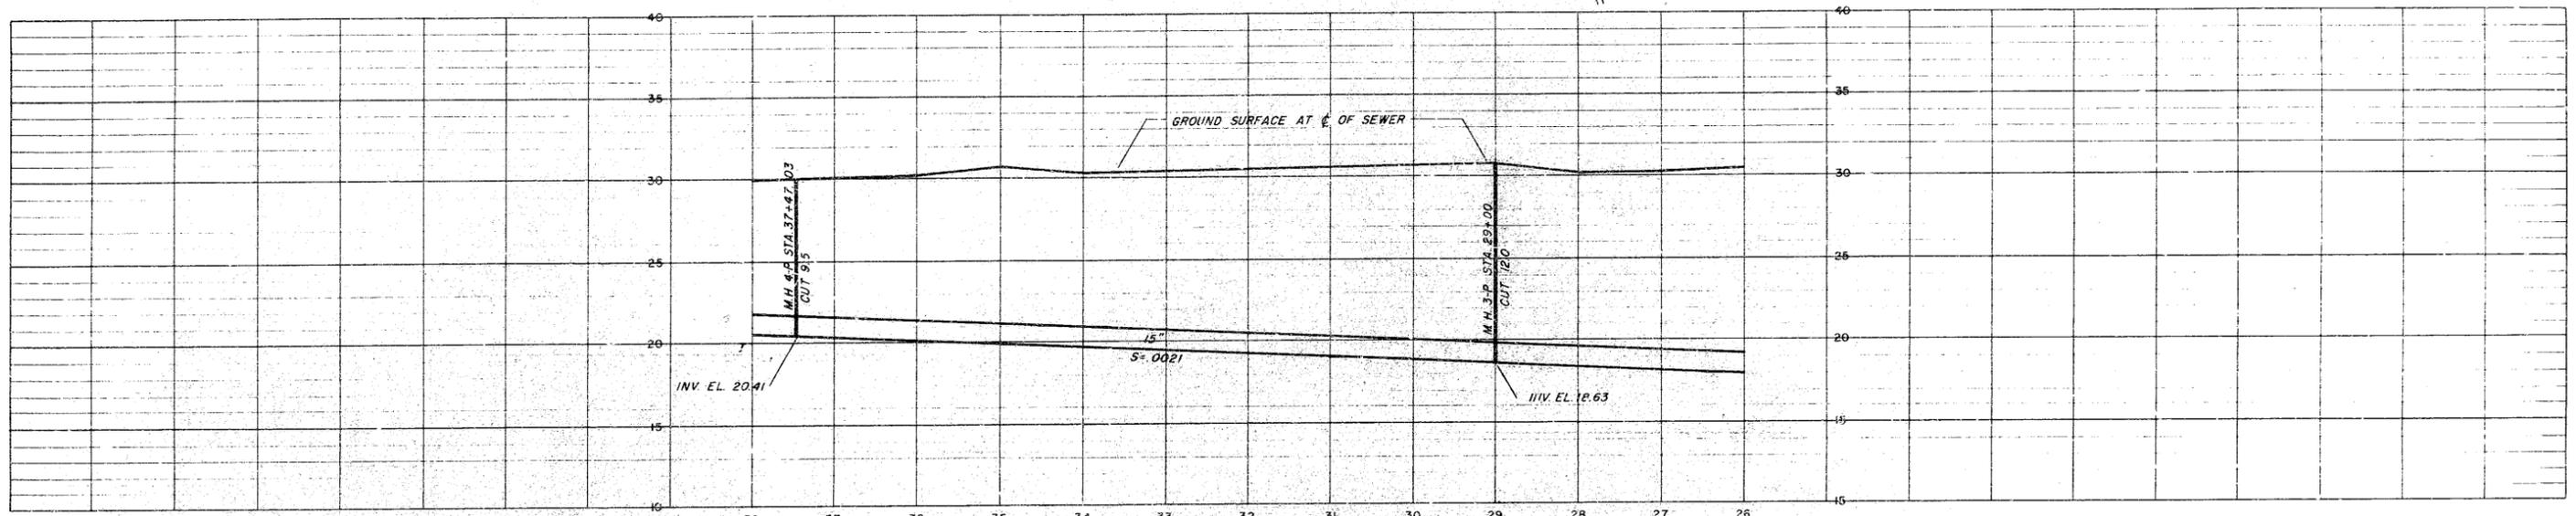

PROFILE AT CENTER OF SEWER
SCALE: HORIZ. 1" = 100', VERT. 1" = 5'

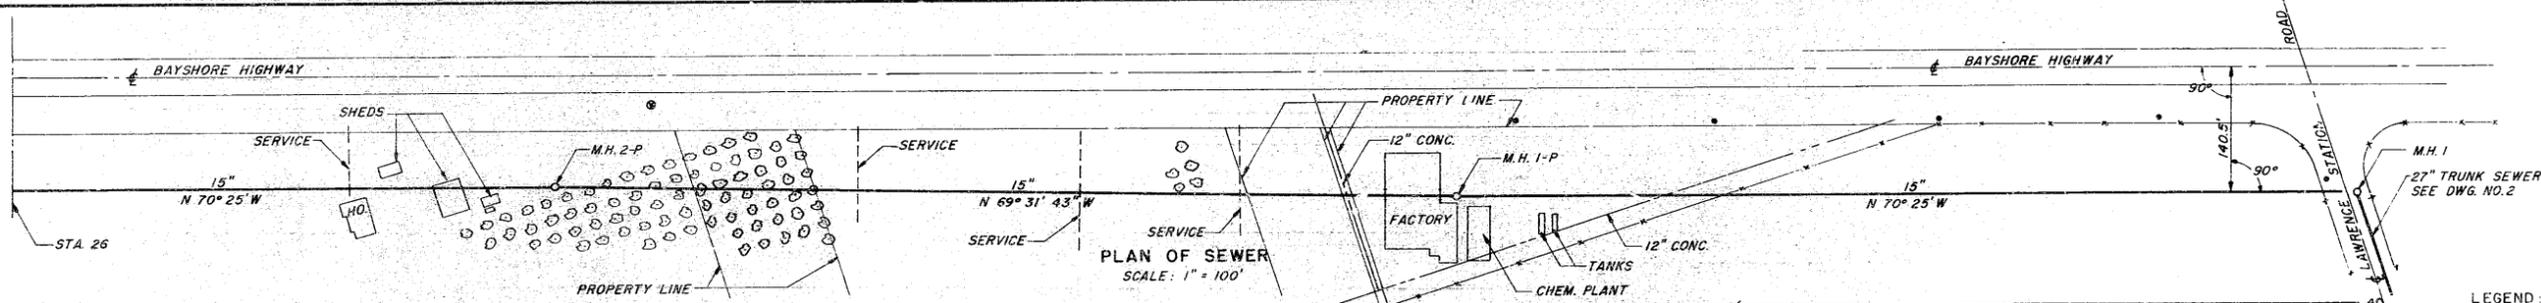

PLAN OF SEWER
SCALE: 1" = 100'

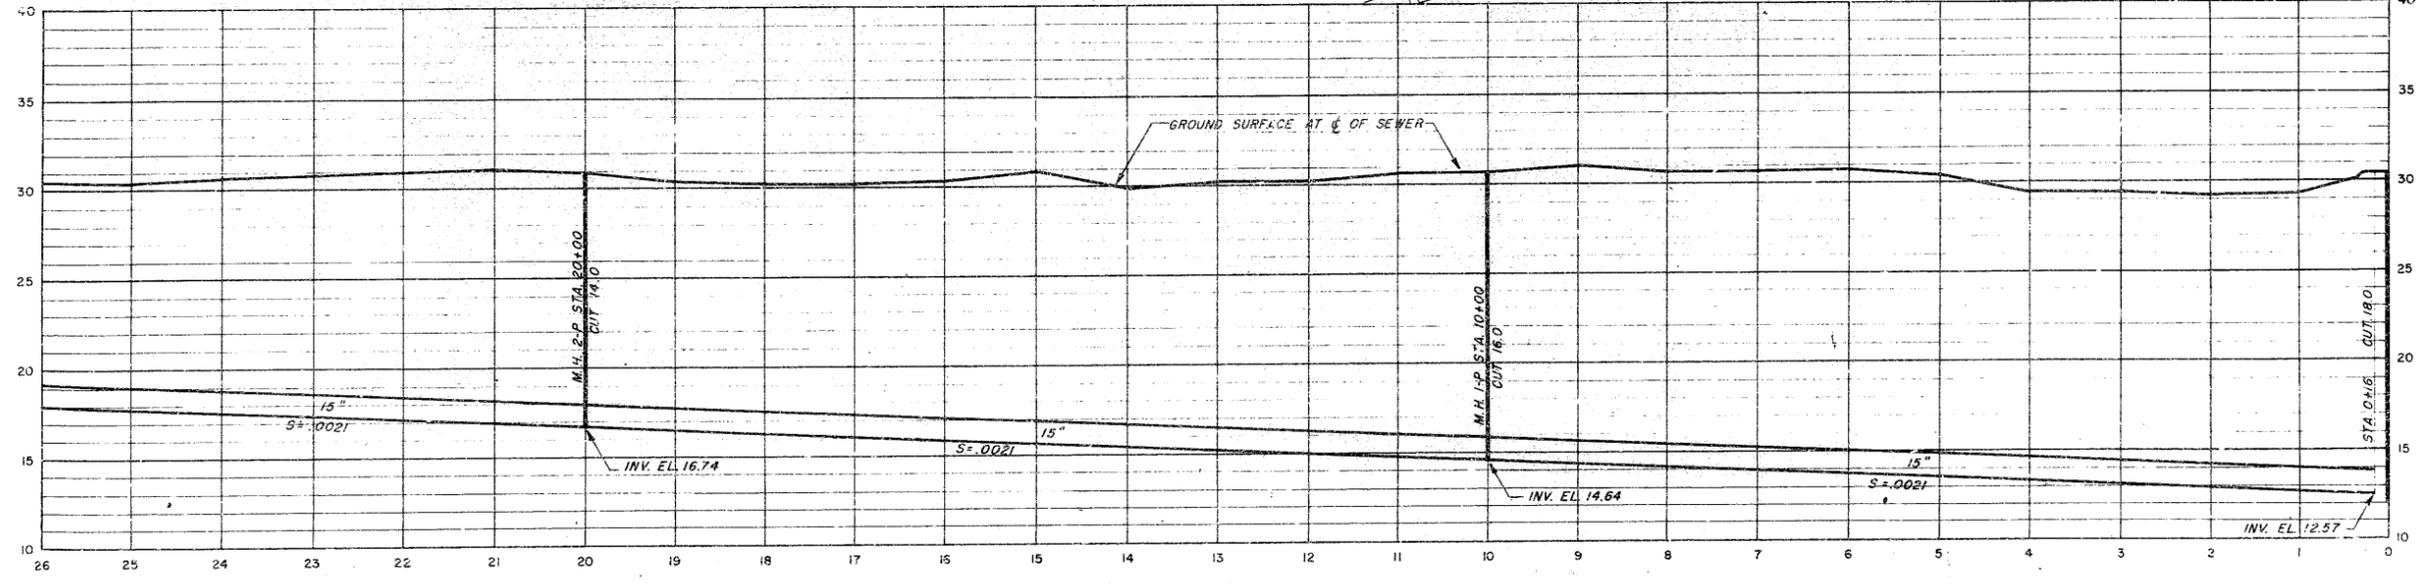

PROFILE AT CENTER OF SEWER
SCALE: HORIZ. 1" = 100', VERT. 1" = 5'

- LEGEND:
- POLE
 - FENCE
 - ⊗ TREE
 - ⊗ BORING WITH SAMPLE
 - BORING
 - WATER
 - - - GAS

NOTE:
ELEVATIONS - CITY OF SUNNYVALE DATUM
ALL STUB TO BE 4 FEET IN LENGTH

CITY OF SUNNYVALE
LAWRENCE STATION ROAD TRUNK SEWER



PLAN AND PROFILE
PRESSURE SEWER
STATION 0 - STATION 38

BROWN AND CALDWELL, CIVIL AND CHEMICAL ENGINEERS
SAN FRANCISCO, CALIFORNIA



DRAWN *[Signature]* CHECKED *[Signature]* DATE 7-15-52 DWG. NO. 7

NOTE: 15" CENTRIFUGAL CONCRETE PRESSURE PIPE WITH DOUBLE RUBBER GASKET JOINT.

SS-108.7

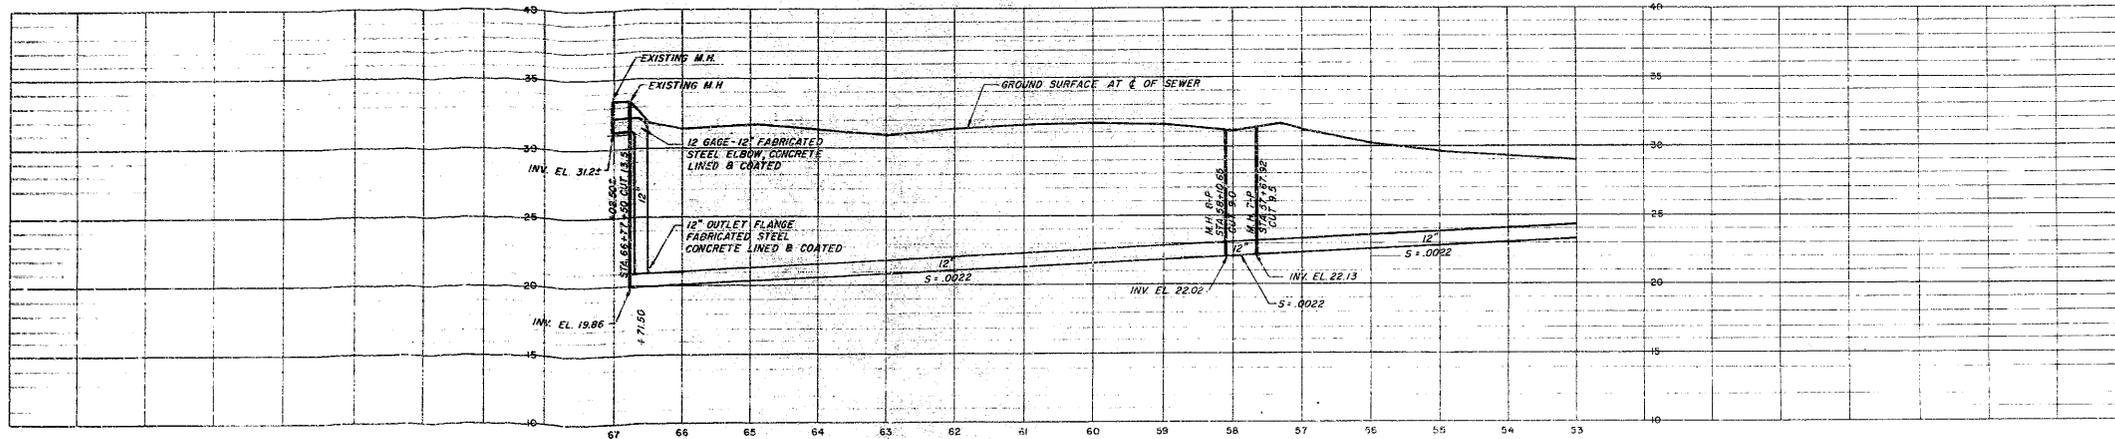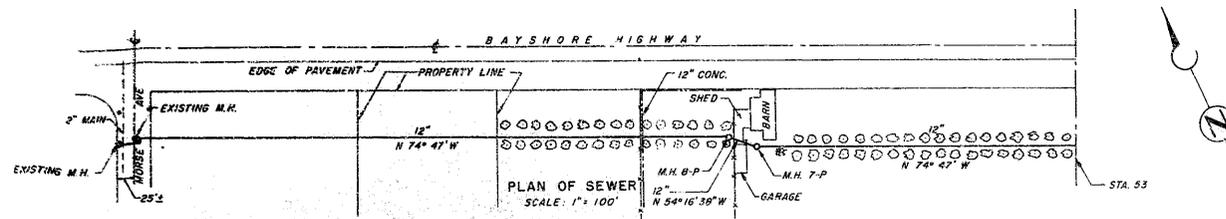

NOTE: 12" CENTRIFUGAL CONCRETE PRESSURE PIPE WITH DOUBLE RUBBER GASKET JOINT

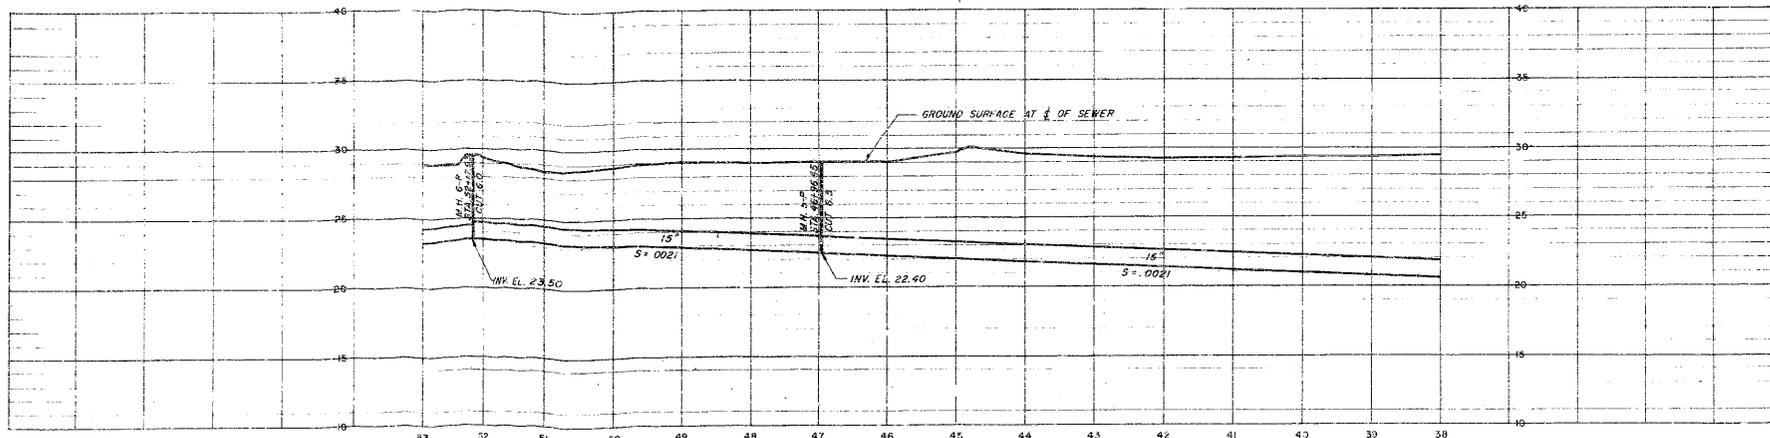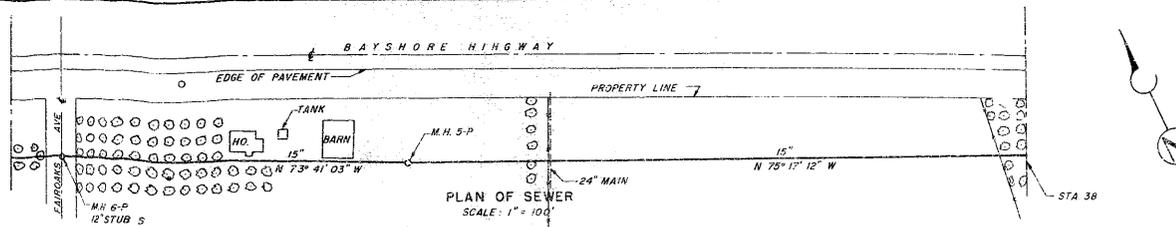

NOTE: 15" CENTRIFUGAL CONCRETE PRESSURE PIPE WITH DOUBLE RUBBER GASKET JOINT

- LEGEND:
- POLE
 - FENCE
 - TREE
 - ⊙ BORING WITH SAMPLE
 - BORING
 - WATER
 - GAS

NOTE:
ELEVATIONS - CITY OF SUNNYVALE DATUM
ALL STUB TO BE 4 FEET IN LENGTH

CITY OF SUNNYVALE
LAWRENCE STATION ROAD TRUNK SEWER

**PLAN AND PROFILE
PRESSURE SEWER
STATION 38- STATION 67+02.5±**

BROWN AND CALDWELL, CIVIL AND CHEMICAL ENGINEERS
SAN FRANCISCO, CALIFORNIA

DRAWN: [] CHECKED: [] DATE: 7-15-34 IOWS NO. 8

55-109.8

